


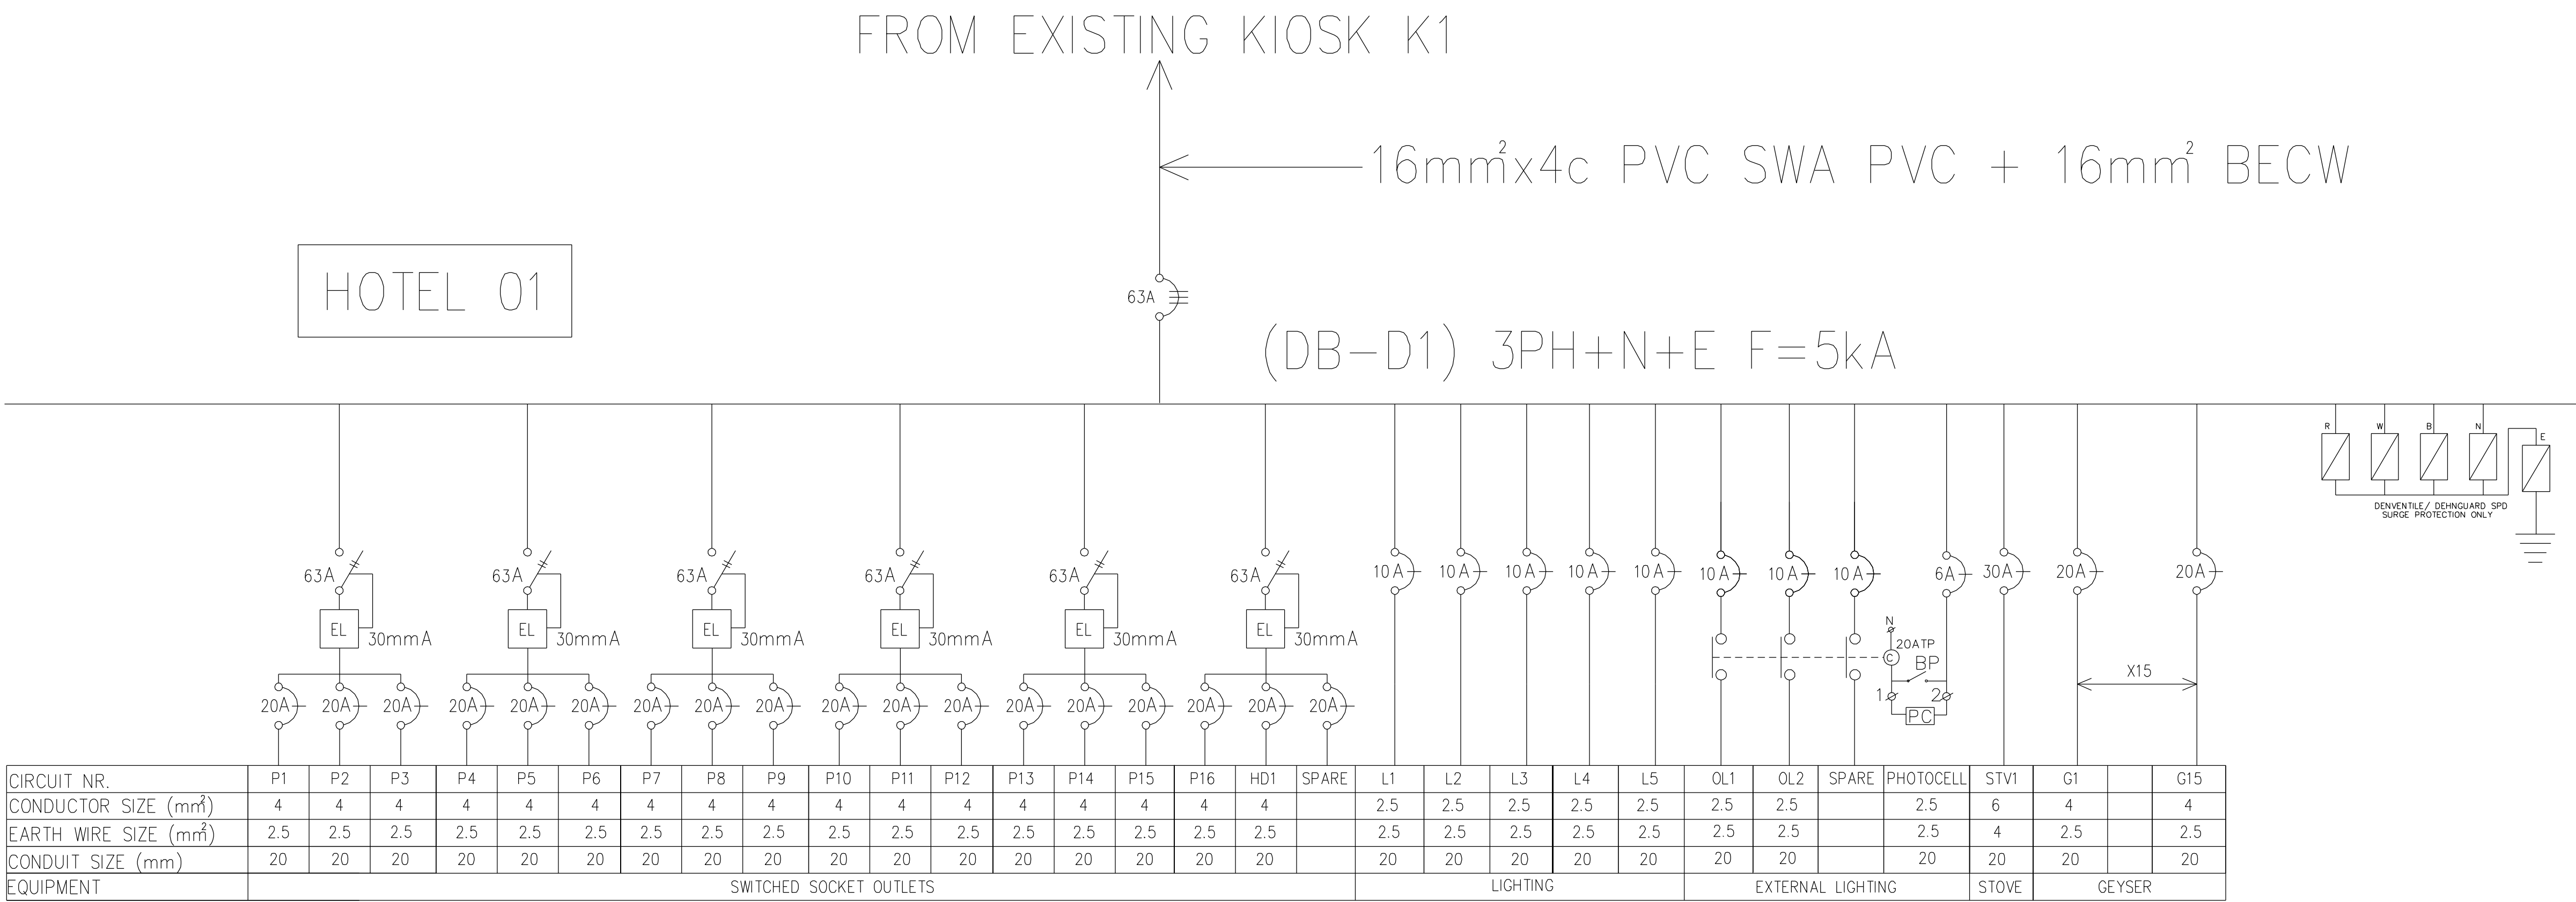

LEGEND:	
P :	NORMAL PLUG CIRCUIT
DP:	DEDICATED PLUG CIRCUIT
AC:	AIR-COND CIRCUIT
EF:	EXTRACTOR FAN CIRCUIT
L :	LIGHTING CIRCUIT
PC:	PHOTOCELL
EL:	EARTH LEAKAGE
G:	GEYSER POINT
STV:	STOVE POINT
SP:	SPARE

	Prepaid meter
HD: HAND DRYER	
FP: FIRE PANEL	
M: MOTORISED CB	
GM: GATE MOTOR	

REV. NO.	DATE	DESCRIPTION
A	19/08/26	TENDER STAGE

MUNICIPAL APPROVAL	
NAME:.....	
SIGNATURE:.....DATE:.....	

STAMPS:

CULENT
PROVINCIAL GOVERNMENT REPUBLIC OF SOUTH AFRICA
DEPARTMENT OF ECONOMIC DEVELOPMENT, ENVIRONMENT & TOURISM
IMPLETING AGENTS
DEVELOPMENT BANK OF SOUTHERN AFRICA Building Africa's Prosperity

ARCHITECTS

28 SILVER STREET, LYTTLETON MANOR, CENTURION: 0157	
TBI 012 640 4177; CELL : 082 238 4122; EMAIL : www.laggaib.co.za	
COMPETENT CONTACT PERSON:	CONT. No: 0604250287
TAURAI MUBAIWA	FIRM REG No:

Copyright vests in the Development Bank of Southern Africa

DISCIPLINE
ELECTRICAL

PROJECT NAME
PROPOSED CONFERENCE CENTRE & HOTELS AT NYSVLEI NATURE RESERVE ON BEHALF OF LIMPOPO ECONOMIC DEVELOPMENT & TOURISM (LEDET)

PROJECT STATUS					
STAGE 1-3		STAGE 4		STAGE 5-6	
CONCEPT	☐	TENDER	☐	CONSTRUCTION	☐
	☐		☐		☐

DESCRIPTION	SCALE: NTS
HOTEL 01 DISTRIBUTION BOARD SINGLE LINE DIAGRAM	

DRAWN:	CHECKED:
NAME OF COMPETENT PERSON: GRACE MAMBOYA	NAME OF COMPETENT PERSON: MAURICE BOKABO
REG No:	REG No: 201470146
SIGNATURE	SIGNATURE
-----	-----

PROJECT NUMBER:	
NATURE OF PROJECT:	DWG No: 2601-E-SLD-02
OCCUPANCY CLASSIFICATION: H2	REV No: A